

 


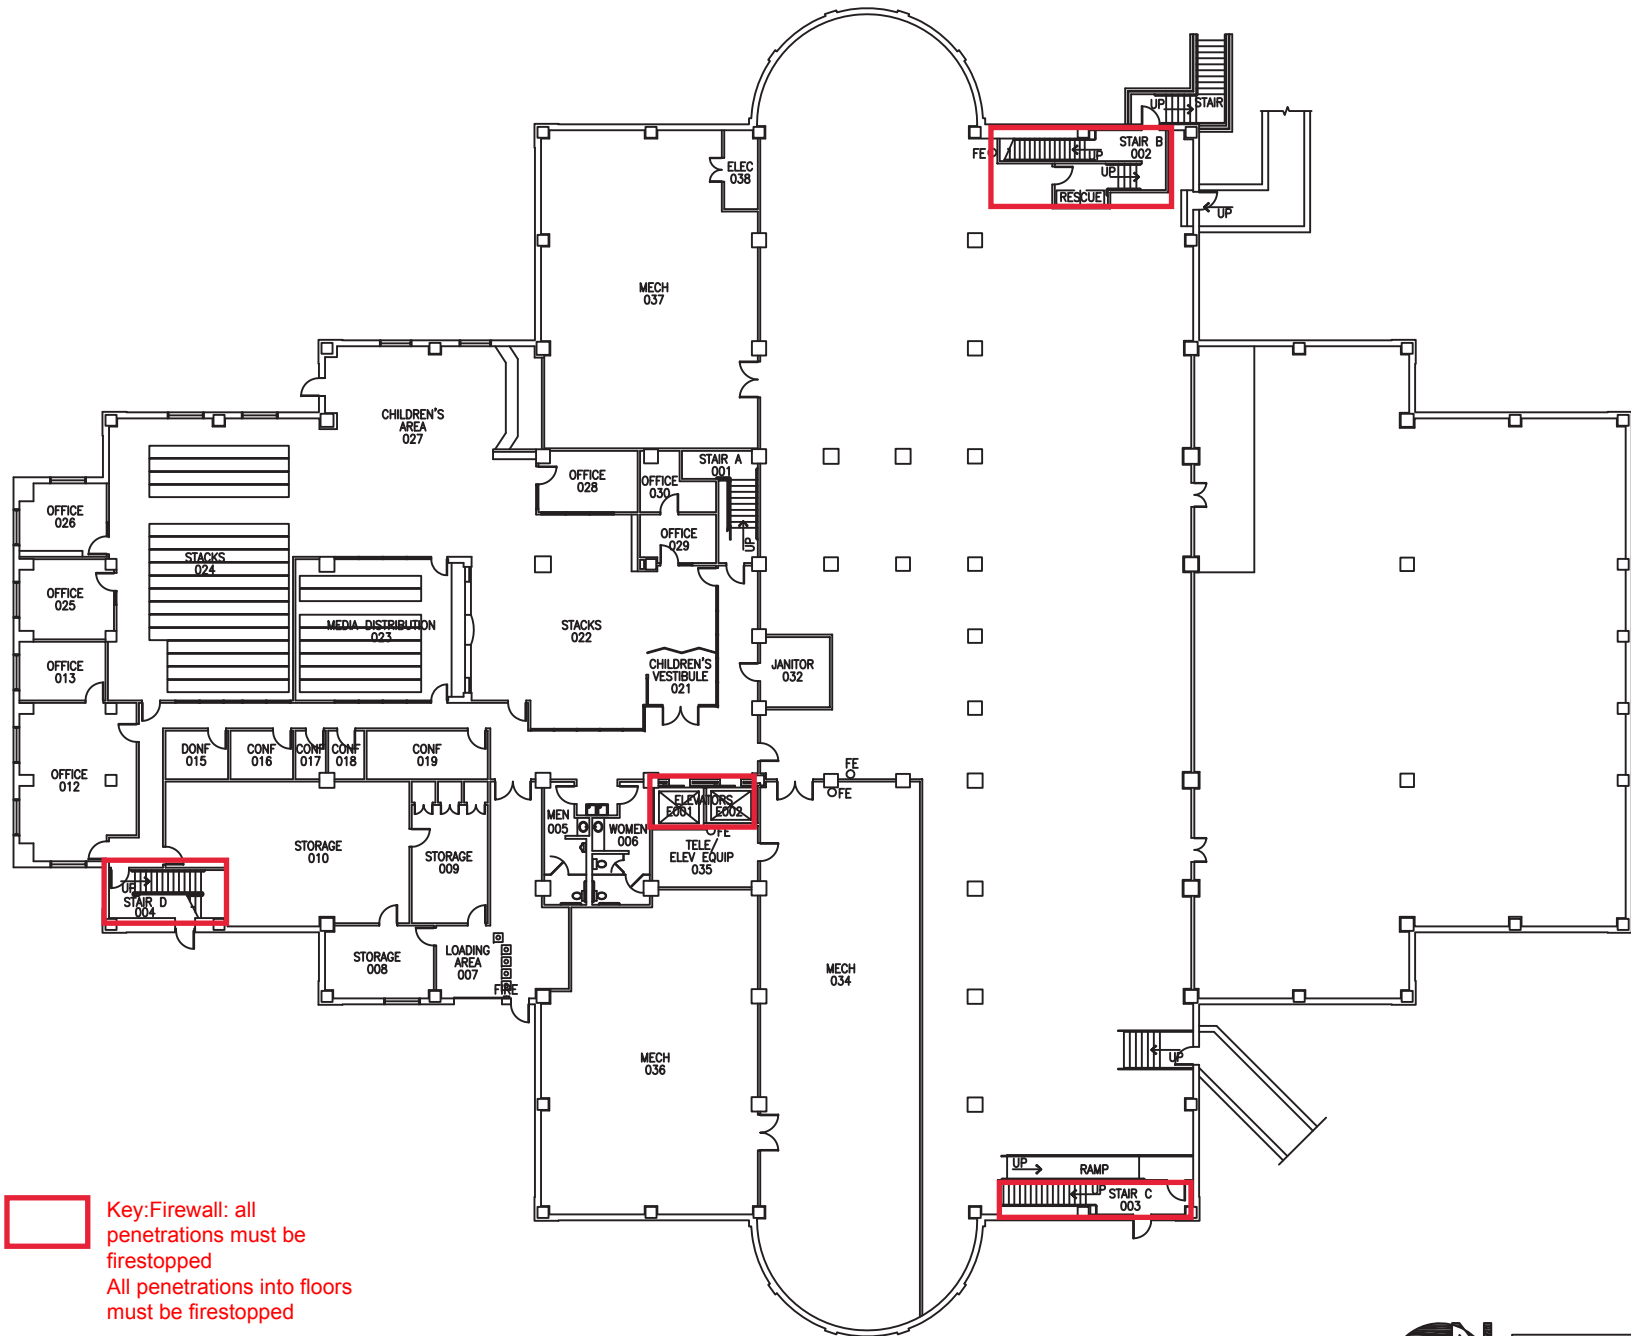


LEGEND	
FIRE PULL	FIRE=
FIRE EXTINGUISHER	FE ○
FIRE EXT IN CABINET	FE □
EYEWASH STATION	EW ○

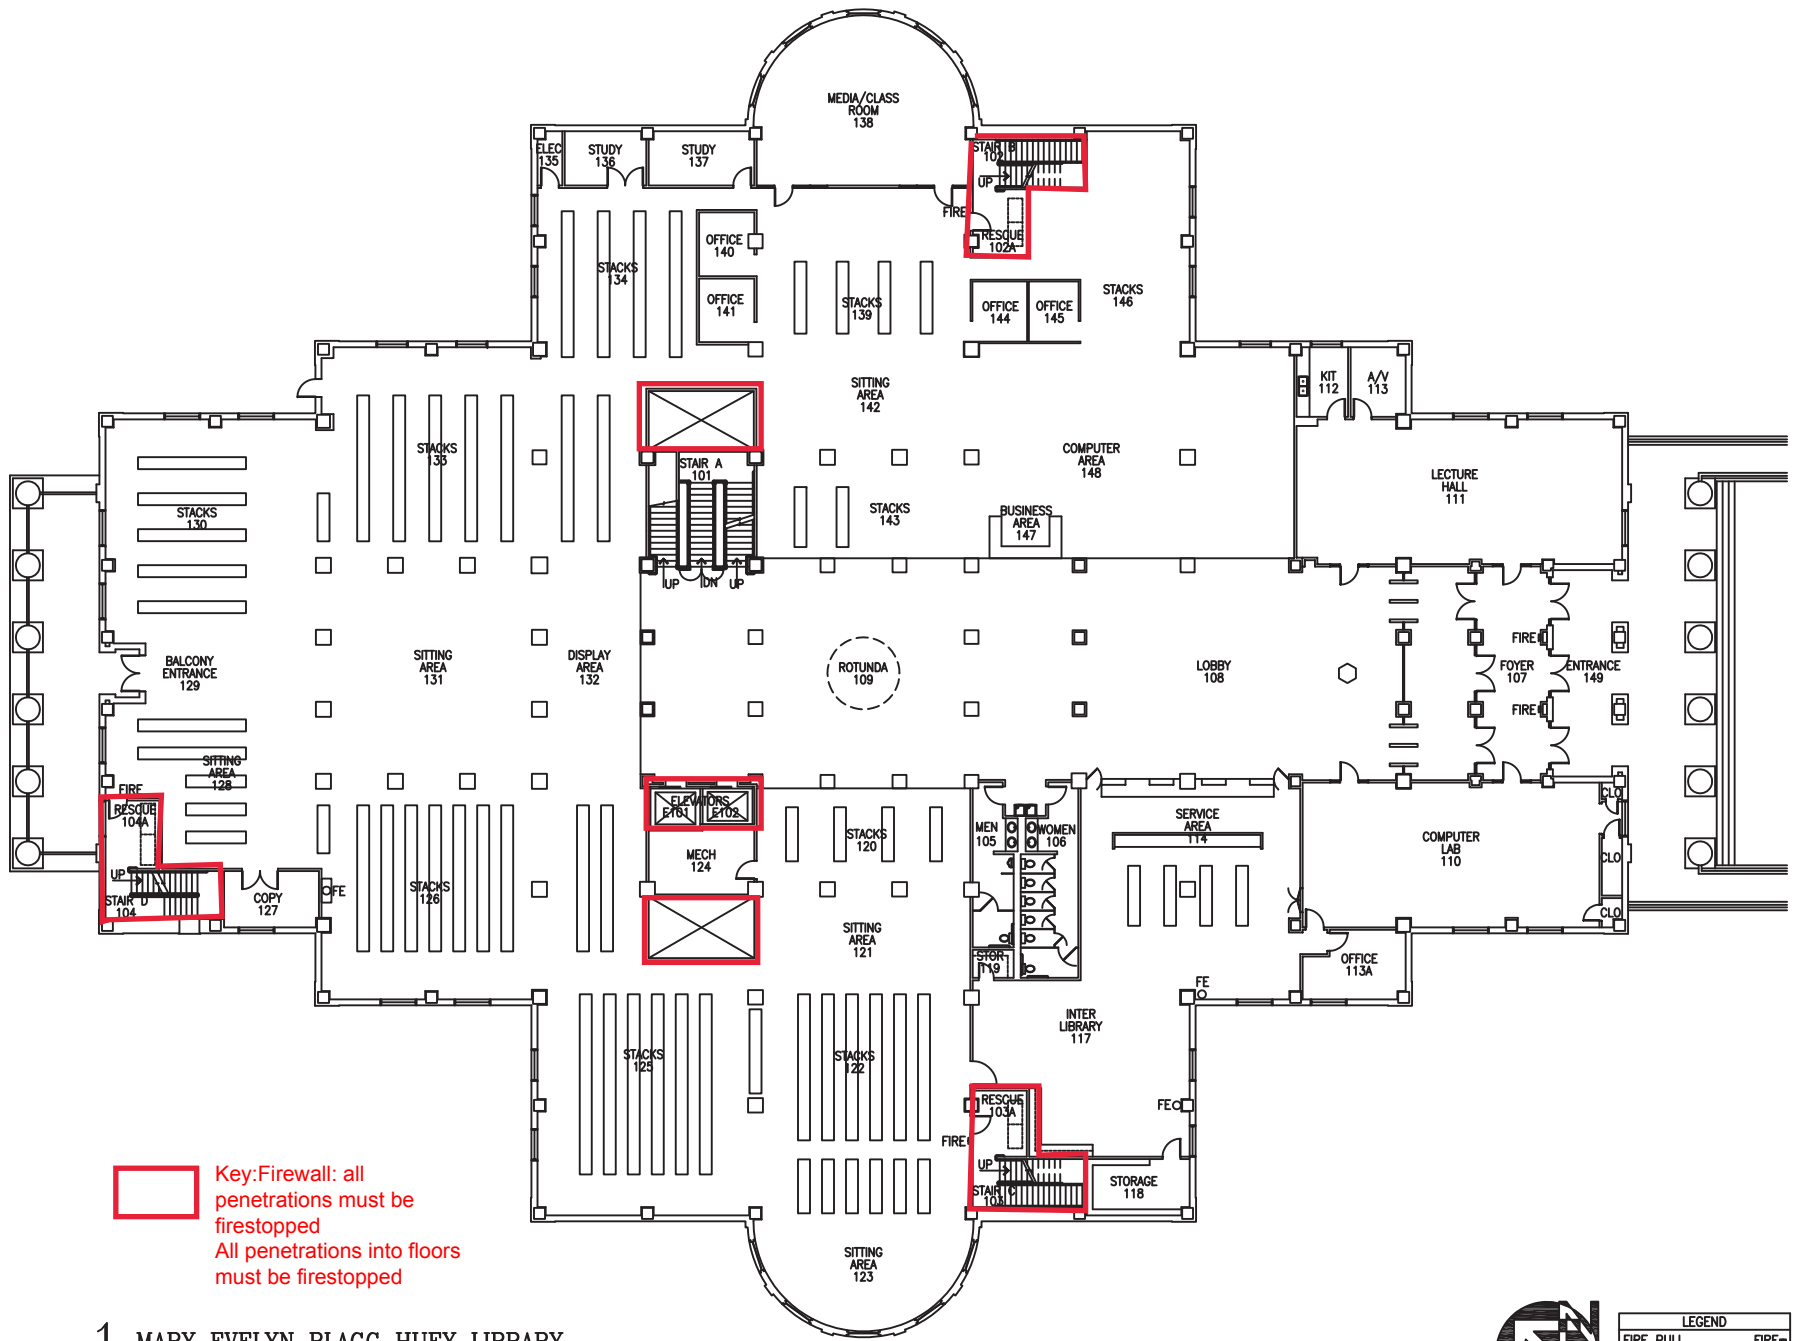

Key: Firewall: all penetrations must be firestopped
All penetrations into floors must be firestopped



LEGEND	
FIRE PULL	FIRE
FIRE EXTINGUISHER	FEO
FIRE EXT IN CABINET	FEC
EYEWASH STATION	EW-O

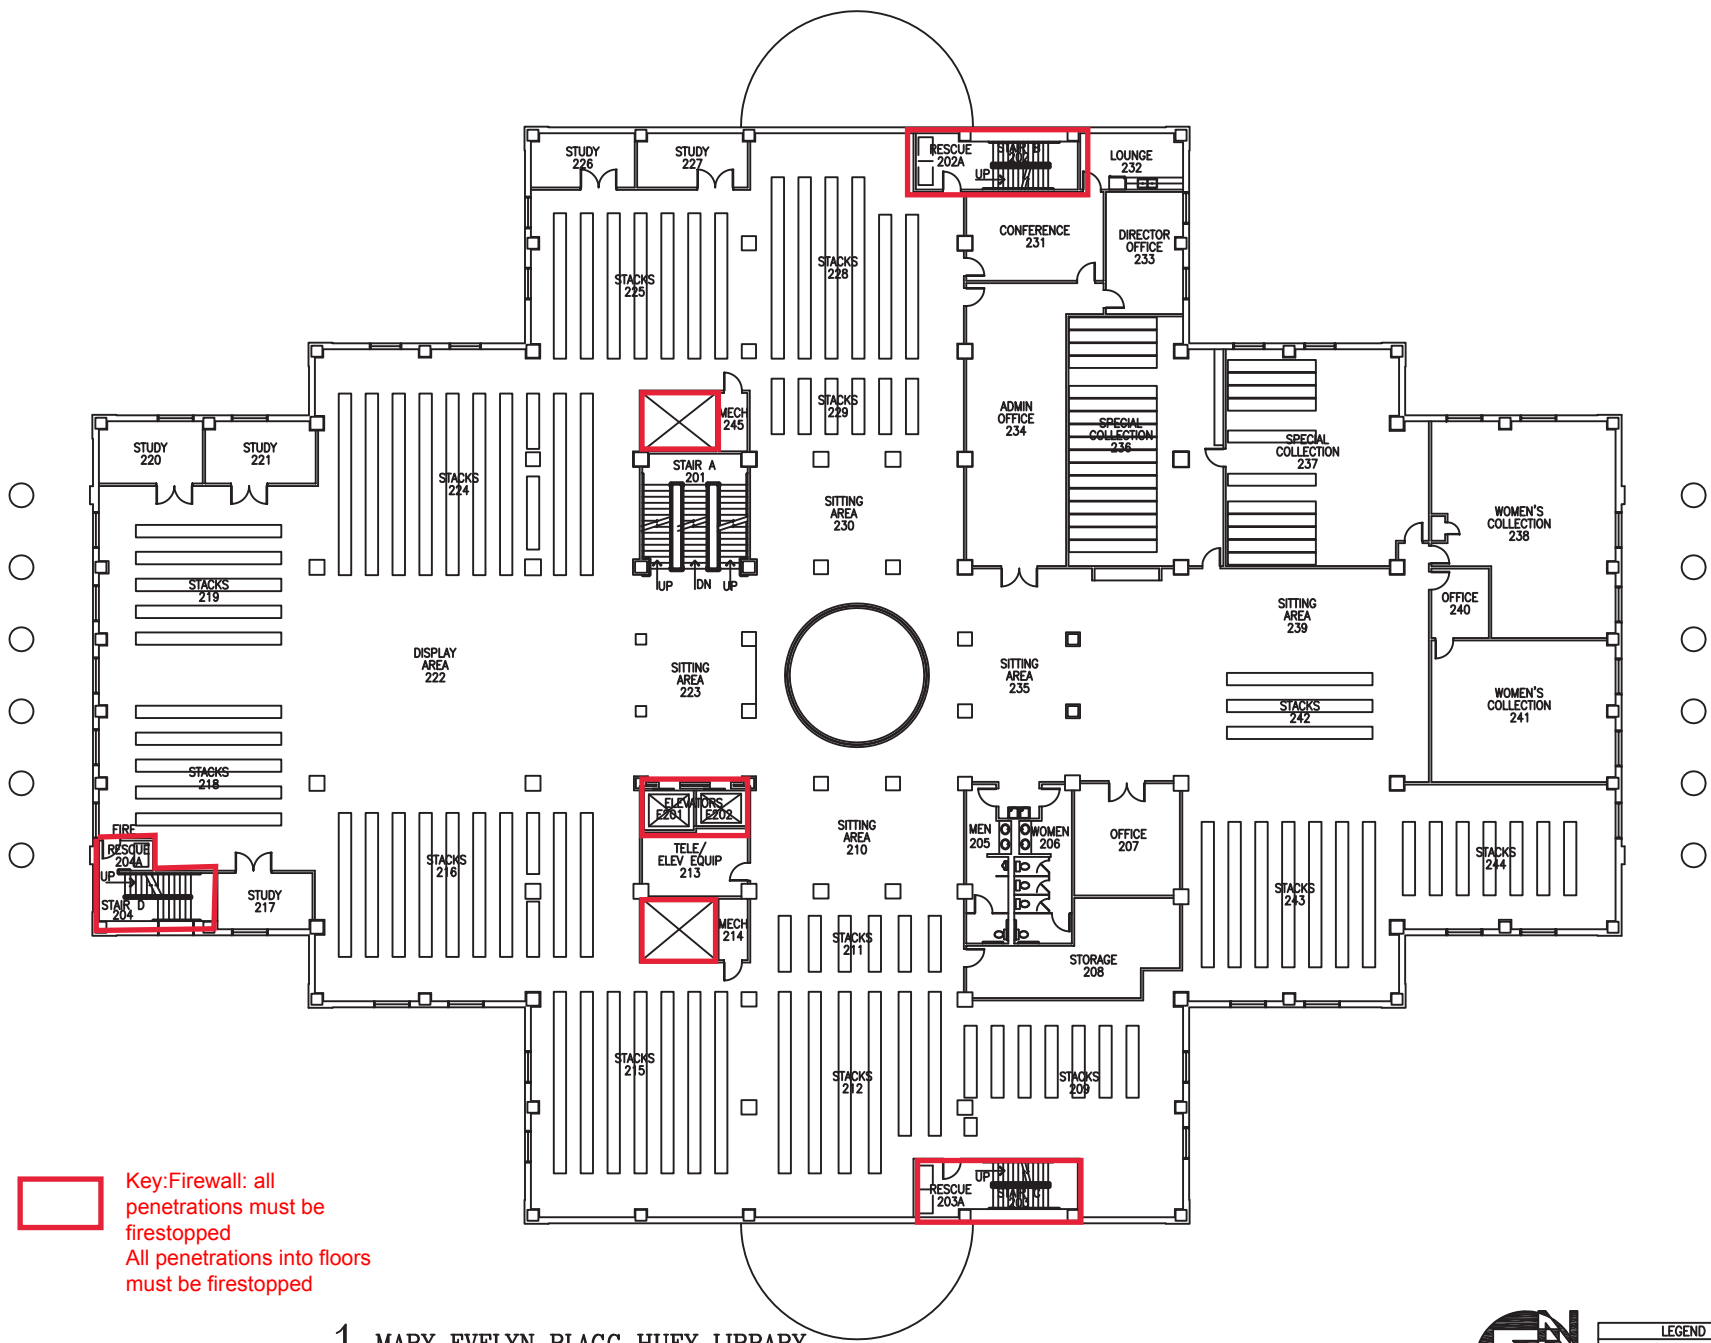


1 MARY EVELYN BLAGG HUEY LIBRARY
2ND FLOOR PLAN

SCALE: 1/32" = 1'-0"



LEGEND	
FIRE PULL	FIRE
FIRE EXTINGUISHER	FE
FIRE EXT IN CABINET FIELD	FE
EYEWASH STATION	EW

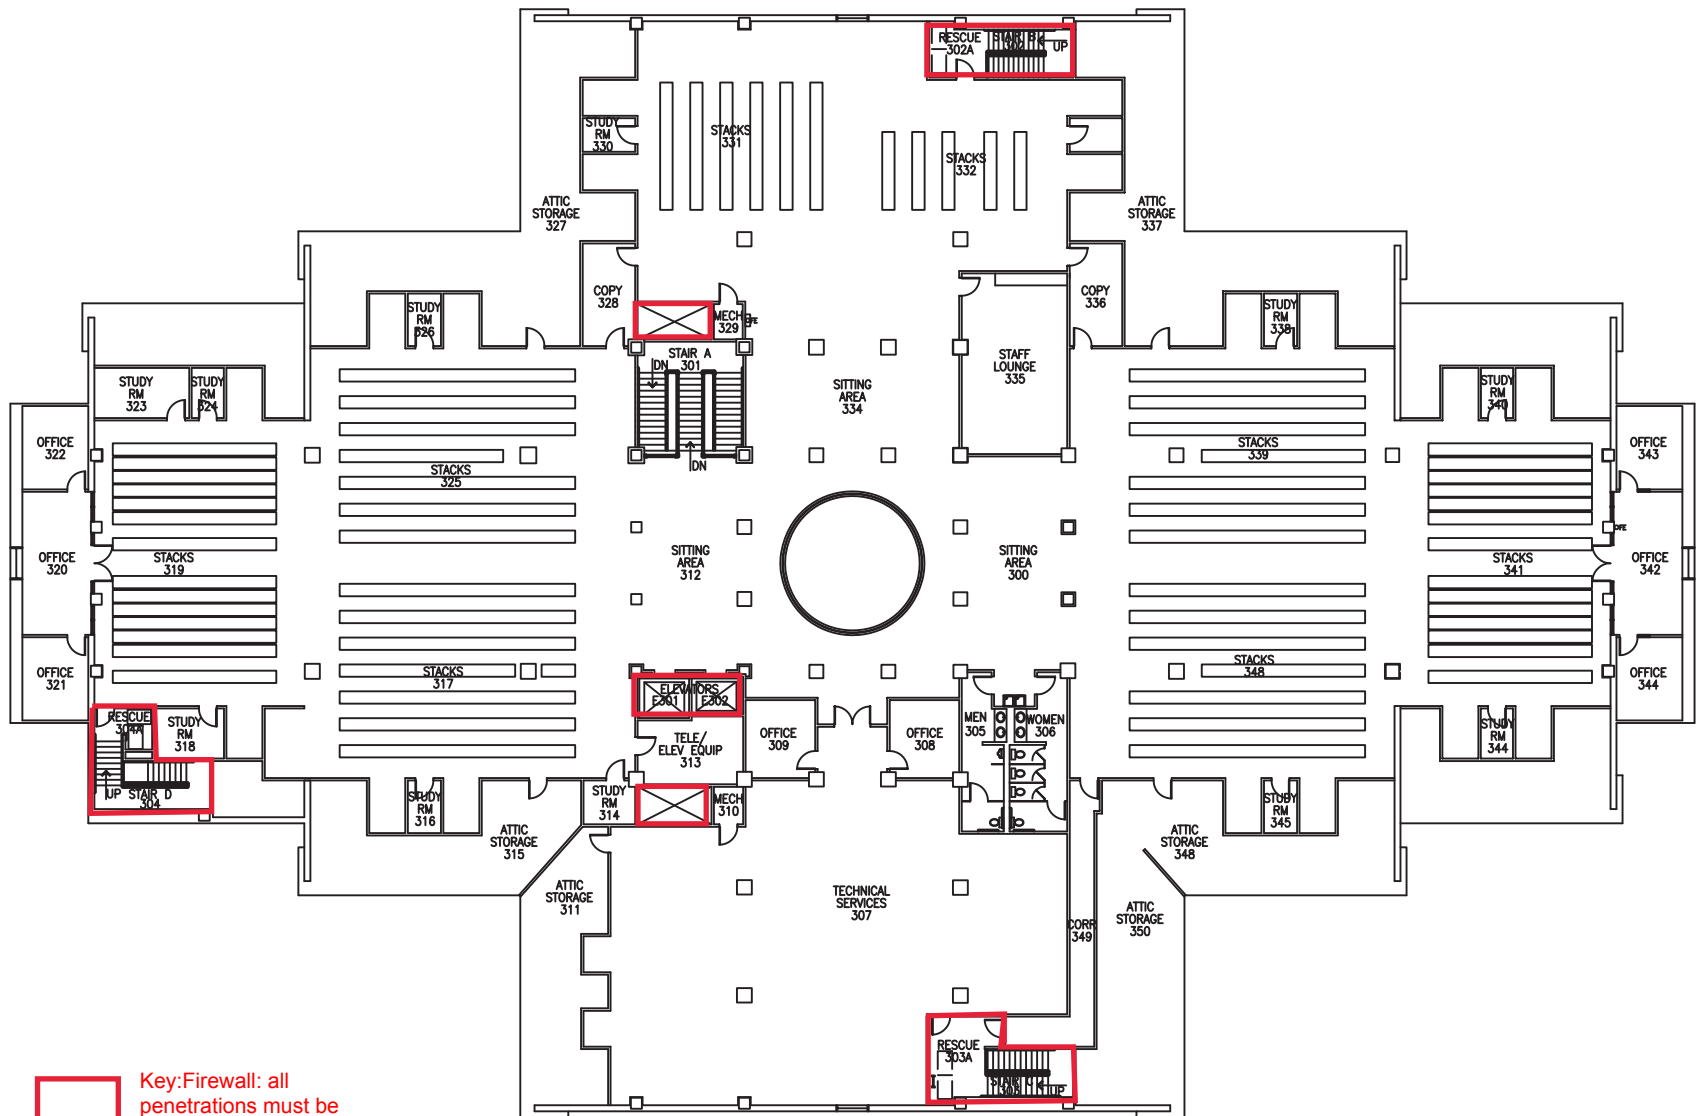

Key:Firewall: all penetrations must be firestopped
 All penetrations into floors must be firestopped

1 MARY EVELYN BLAGG HUEY LIBRARY
 3RD FLOOR PLAN

SCALE: 1/32" = 1'-0"



LEGEND	
FIRE PULL	FIRE=
FIRE EXTINGUISHER	FE O
FIRE EXT IN CABINET	FE O
EYEWASH STATION	EW-O